

The seal of the Louisiana National Guard is a circular emblem. It features a blue outer ring with the words "LOUISIANA NATIONAL GUARD" in white, uppercase letters at the top and "ALWAYS READY ALWAYS THERE" at the bottom, separated by two white stars. The center of the seal is a red circle containing a white silhouette of a Minuteman soldier standing and holding a long rifle.

CAMP VILLENE
SLIDELL, LA

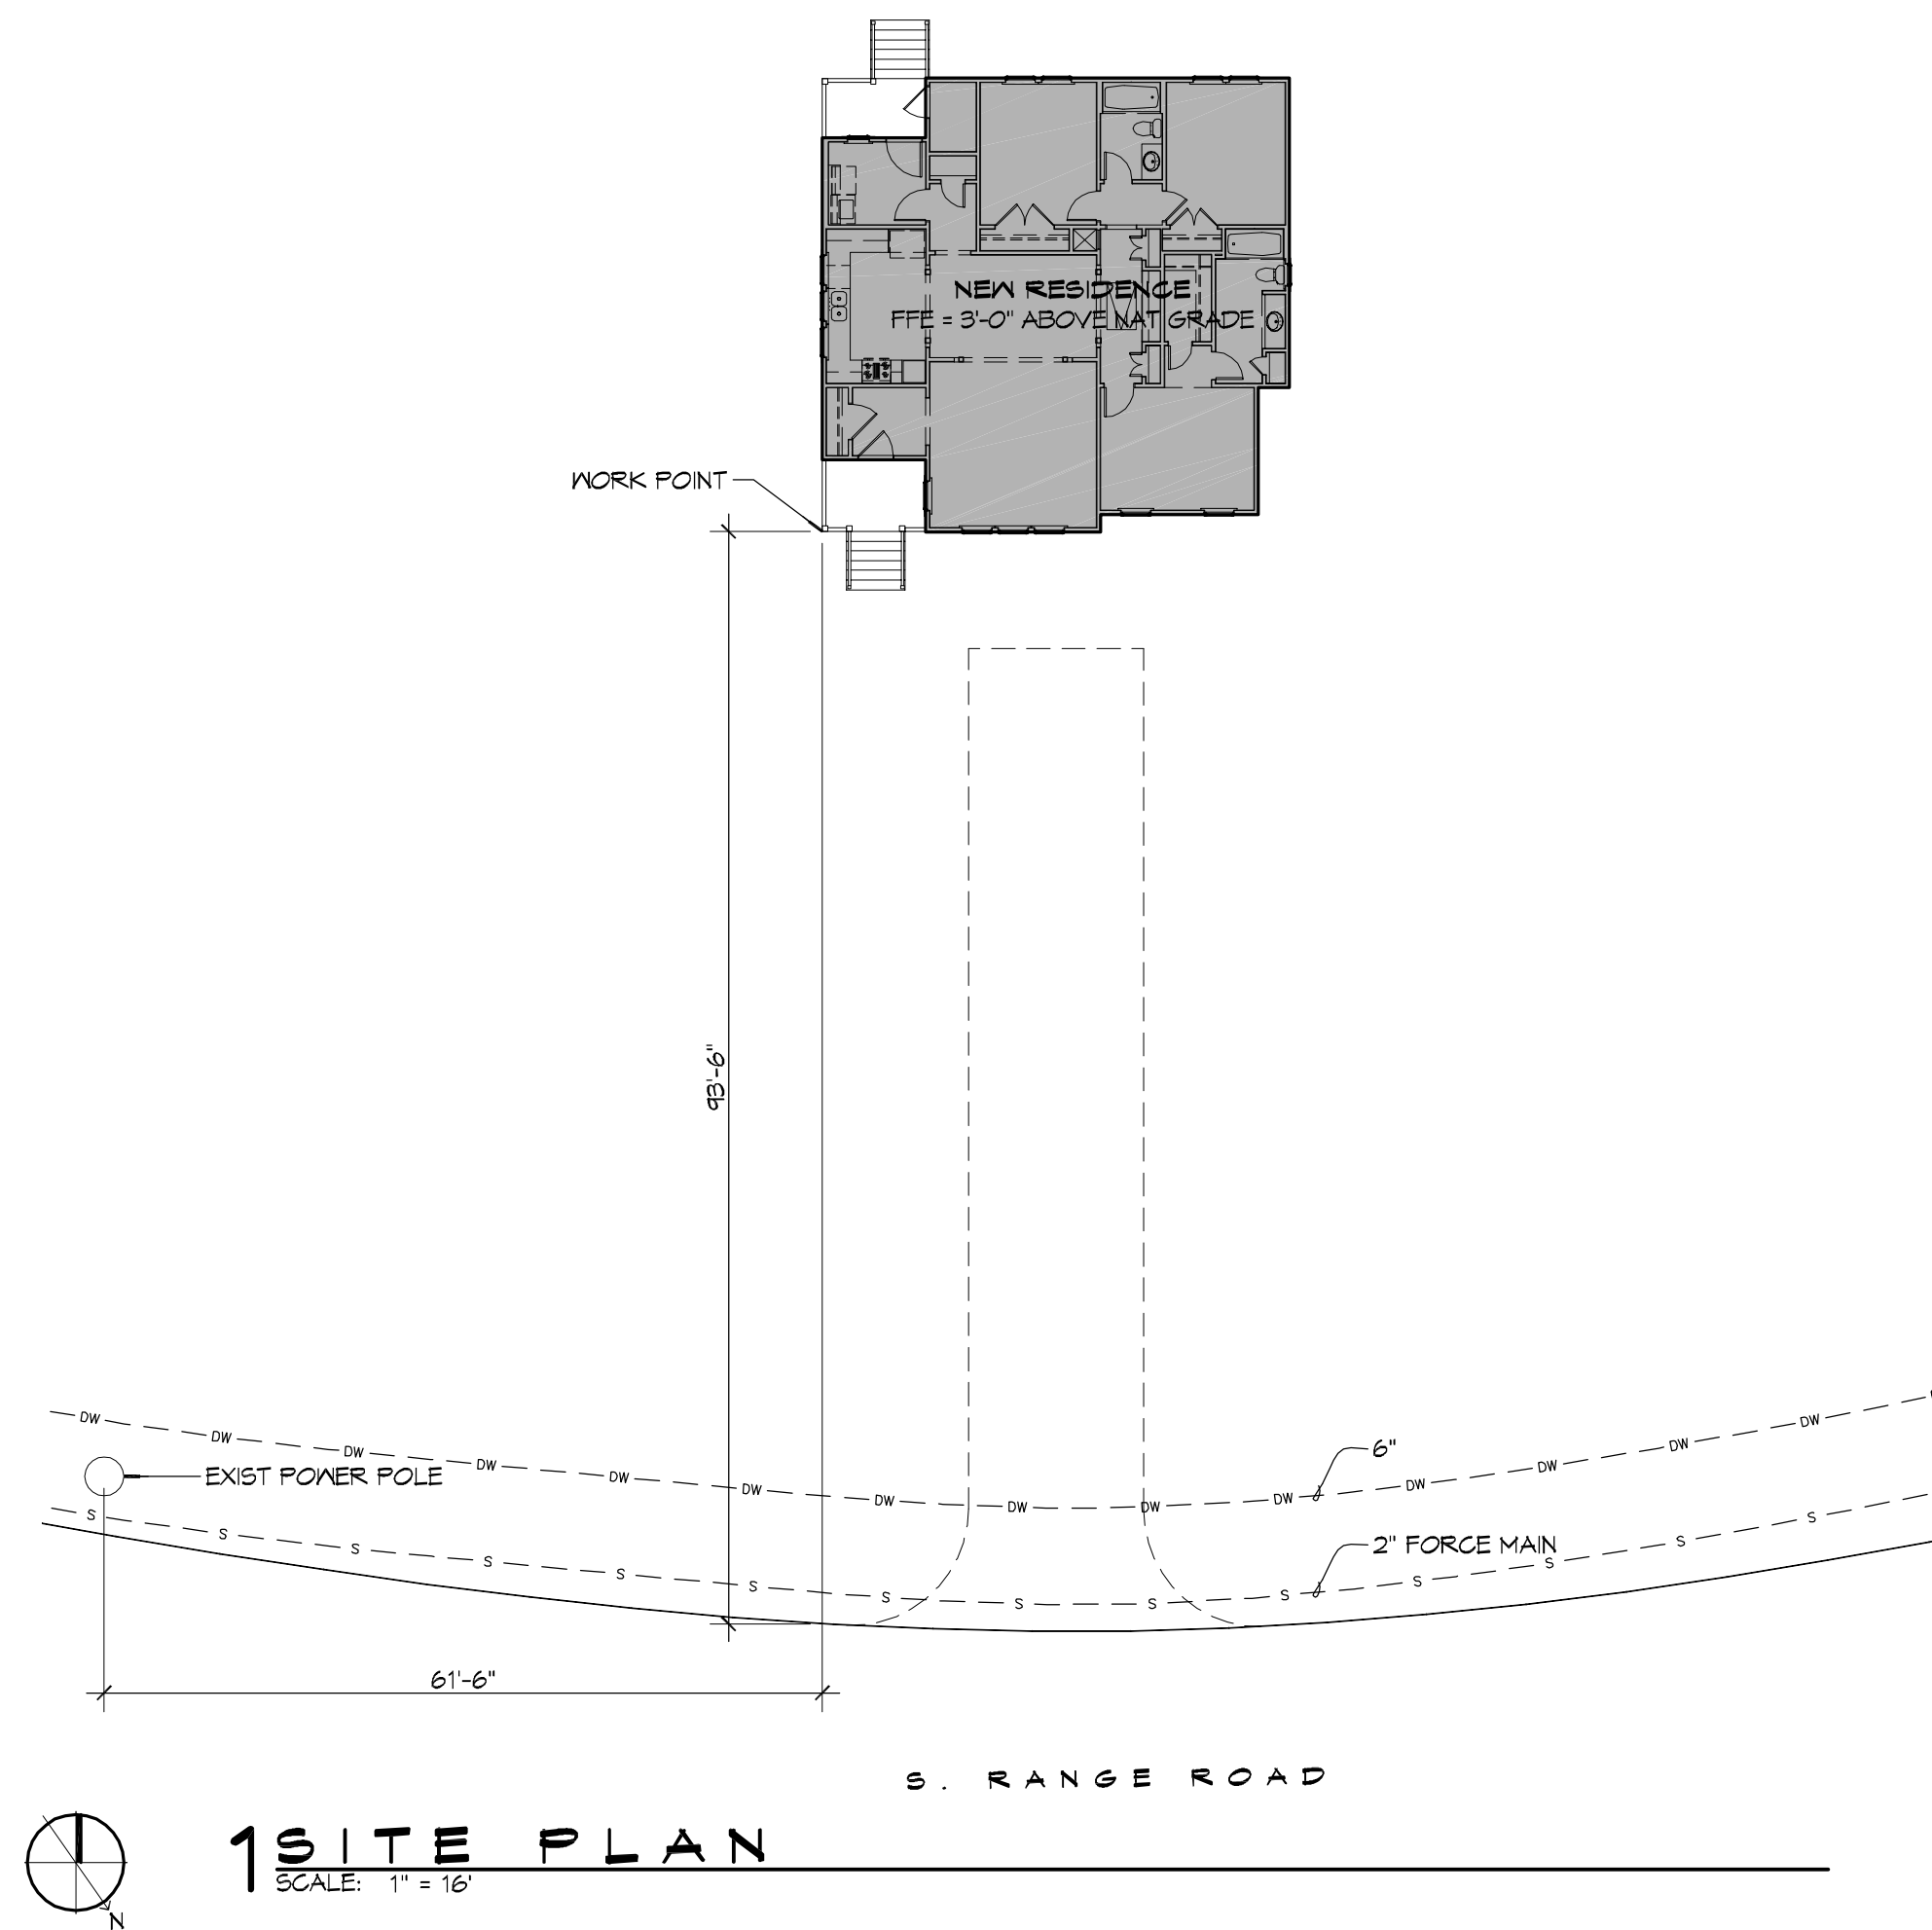


Diagram illustrating various architectural symbols and their corresponding labels:

- Ceiling Height:** 0'-0" ACT
- Ceiling Material:** ACT
- Area of Detail to be Enlarged:** 1/4"
- Sheet Number:** 1/4"
- Detail Number:** 1/4"
- Elevation Tag:** X/XXX
- Section Tag:** 1/4"
- Column Grid Identifier:** A
- Revision Tag & Cloud:** 1
- Finished Ceiling Designation Symbol:** N
- Drawing No.:** 1
- Drawing Title:** PLAN
- Scale:** SCALE
- True North:** N
- Plan North:** N
- Drawing Scale:** SCALE
- Drawing Subtitle:** Subtitle
- Room Name:** ENTRY
- Room Number:** 101
- Partition Type Tag:** P1
- Level:** LEVEL X
- Window - Louver Opening Designation:** XX
- Door Opening Designation:** XXX
- Key Note (Sheet Specific):** X

SHEET #	SHEET TITLE
G1	GENERAL INFORMATION SHEET
S1	FRAMING PLAN - DETAILS AND NOTES
A1	ARCHITECTURAL FLOOR PLAN & SCHEDULES
A2	EXTERIOR ELEVATIONS
A3	SECTIONS AND DETAILS
A4	REFLECTED CEILING PLAN
A5	STRAPPING AND CONNECTION DETAILS
M1	MECHANICAL PLAN - HVAC, DETAILS AND NOTES
E1	ELECTRICAL PLANS - POWER, LIGHTING, AND PANEL DIAGRAMS
P1	PLUMBING RISER DIAGRAM AND NOTES

1. ALL MATERIALS AND WORK, INCIDENTAL TO THE CONSTRUCTION OF THIS PROJECT, SHALL CONFORM TO ALL GOVERNING CODES, AND REGULATIONS OF AGENCIES IN AUTHORITY.
2. CONTRACTOR SHALL PROVIDE ALL PUBLIC PROTECTIONS NECESSARY AS REQUIRED BY LAW.
3. THE DRAWINGS, SPECIFICATIONS AND ANY SUBSEQUENTLY ISSUED ADDENDA, AMENDMENTS OR SUCH CHANGE ORDERS APPROVED BY THE OWNER AND THE CONTRACTOR ARE PART OF THESE CONTRACT DOCUMENTS.
4. **DO NOT SCALE DRAWINGS.** CONSULT WITH THE ARCHITECT REGARDING ANY ITEMS IN THE CONTRACT DOCUMENTS THAT REQUIRE CLARIFICATION.
5. TRASH SHALL BE REMOVED FROM THE SITE NOT LESS THAN TWICE MONTHLY.
6. THE GENERAL CONTRACTOR SHALL VERIFY EXISTING CONDITIONS PRIOR TO COMMENCING WORK AND REPORT ANY AND ALL DISCREPANCIES TO THE ARCHITECT.
7. CONTRACTOR VEHICLES AND EQUIPMENT NECESSARY FOR CONSTRUCTION MUST BE PARKED ON THE SITE. OTHER VEHICLES PARKED ON THE SITE REQUIRE THE OWNER'S PERMISSION.
8. NAMING A CERTAIN BRAND, MAKE OR MANUFACTURER IS TO DESIGNATE THE GENERAL STYLE, TYPE, CHARACTER AND QUALITY STANDARD OF THE PRODUCT DESIRED. SUBSTITUTION REQUESTS MUST BE SUBMITTED PRIOR TO BIDDING.
9. ALL MATERIALS/EQUIPMENT SHALL BE INSTALLED PER MANUFACTURER'S RECOMMENDATIONS. WORK NOT CONSISTENT WITH MANUFACTURER'S RECOMMENDATIONS WILL BE REJECTED BY OWNER/ARCHITECT.

[illegible]

SEAL:

50% SUBMITTAL

**NOT FOR
CONSTRUCTION**

POSTER SESSIONS

SHEET TITLE:
GENERAL INFORMATION
SHEET AND SITE PLAN

DRAWING NUMBER:

G1


SHEET No: 1 of 10

DAMMON
ENGINEERING, INC.

Architects & Engineers

Chief Architect: Kevin J. Knochel, NCARB
Chief Engineer: Brian Mitchell, PE
554 Old Spanish Trail
Slidell, LA 70458

www.dammonengineering.com
info@dammonengineering.com
PH: 985.495.4832
F: 985.641.5950

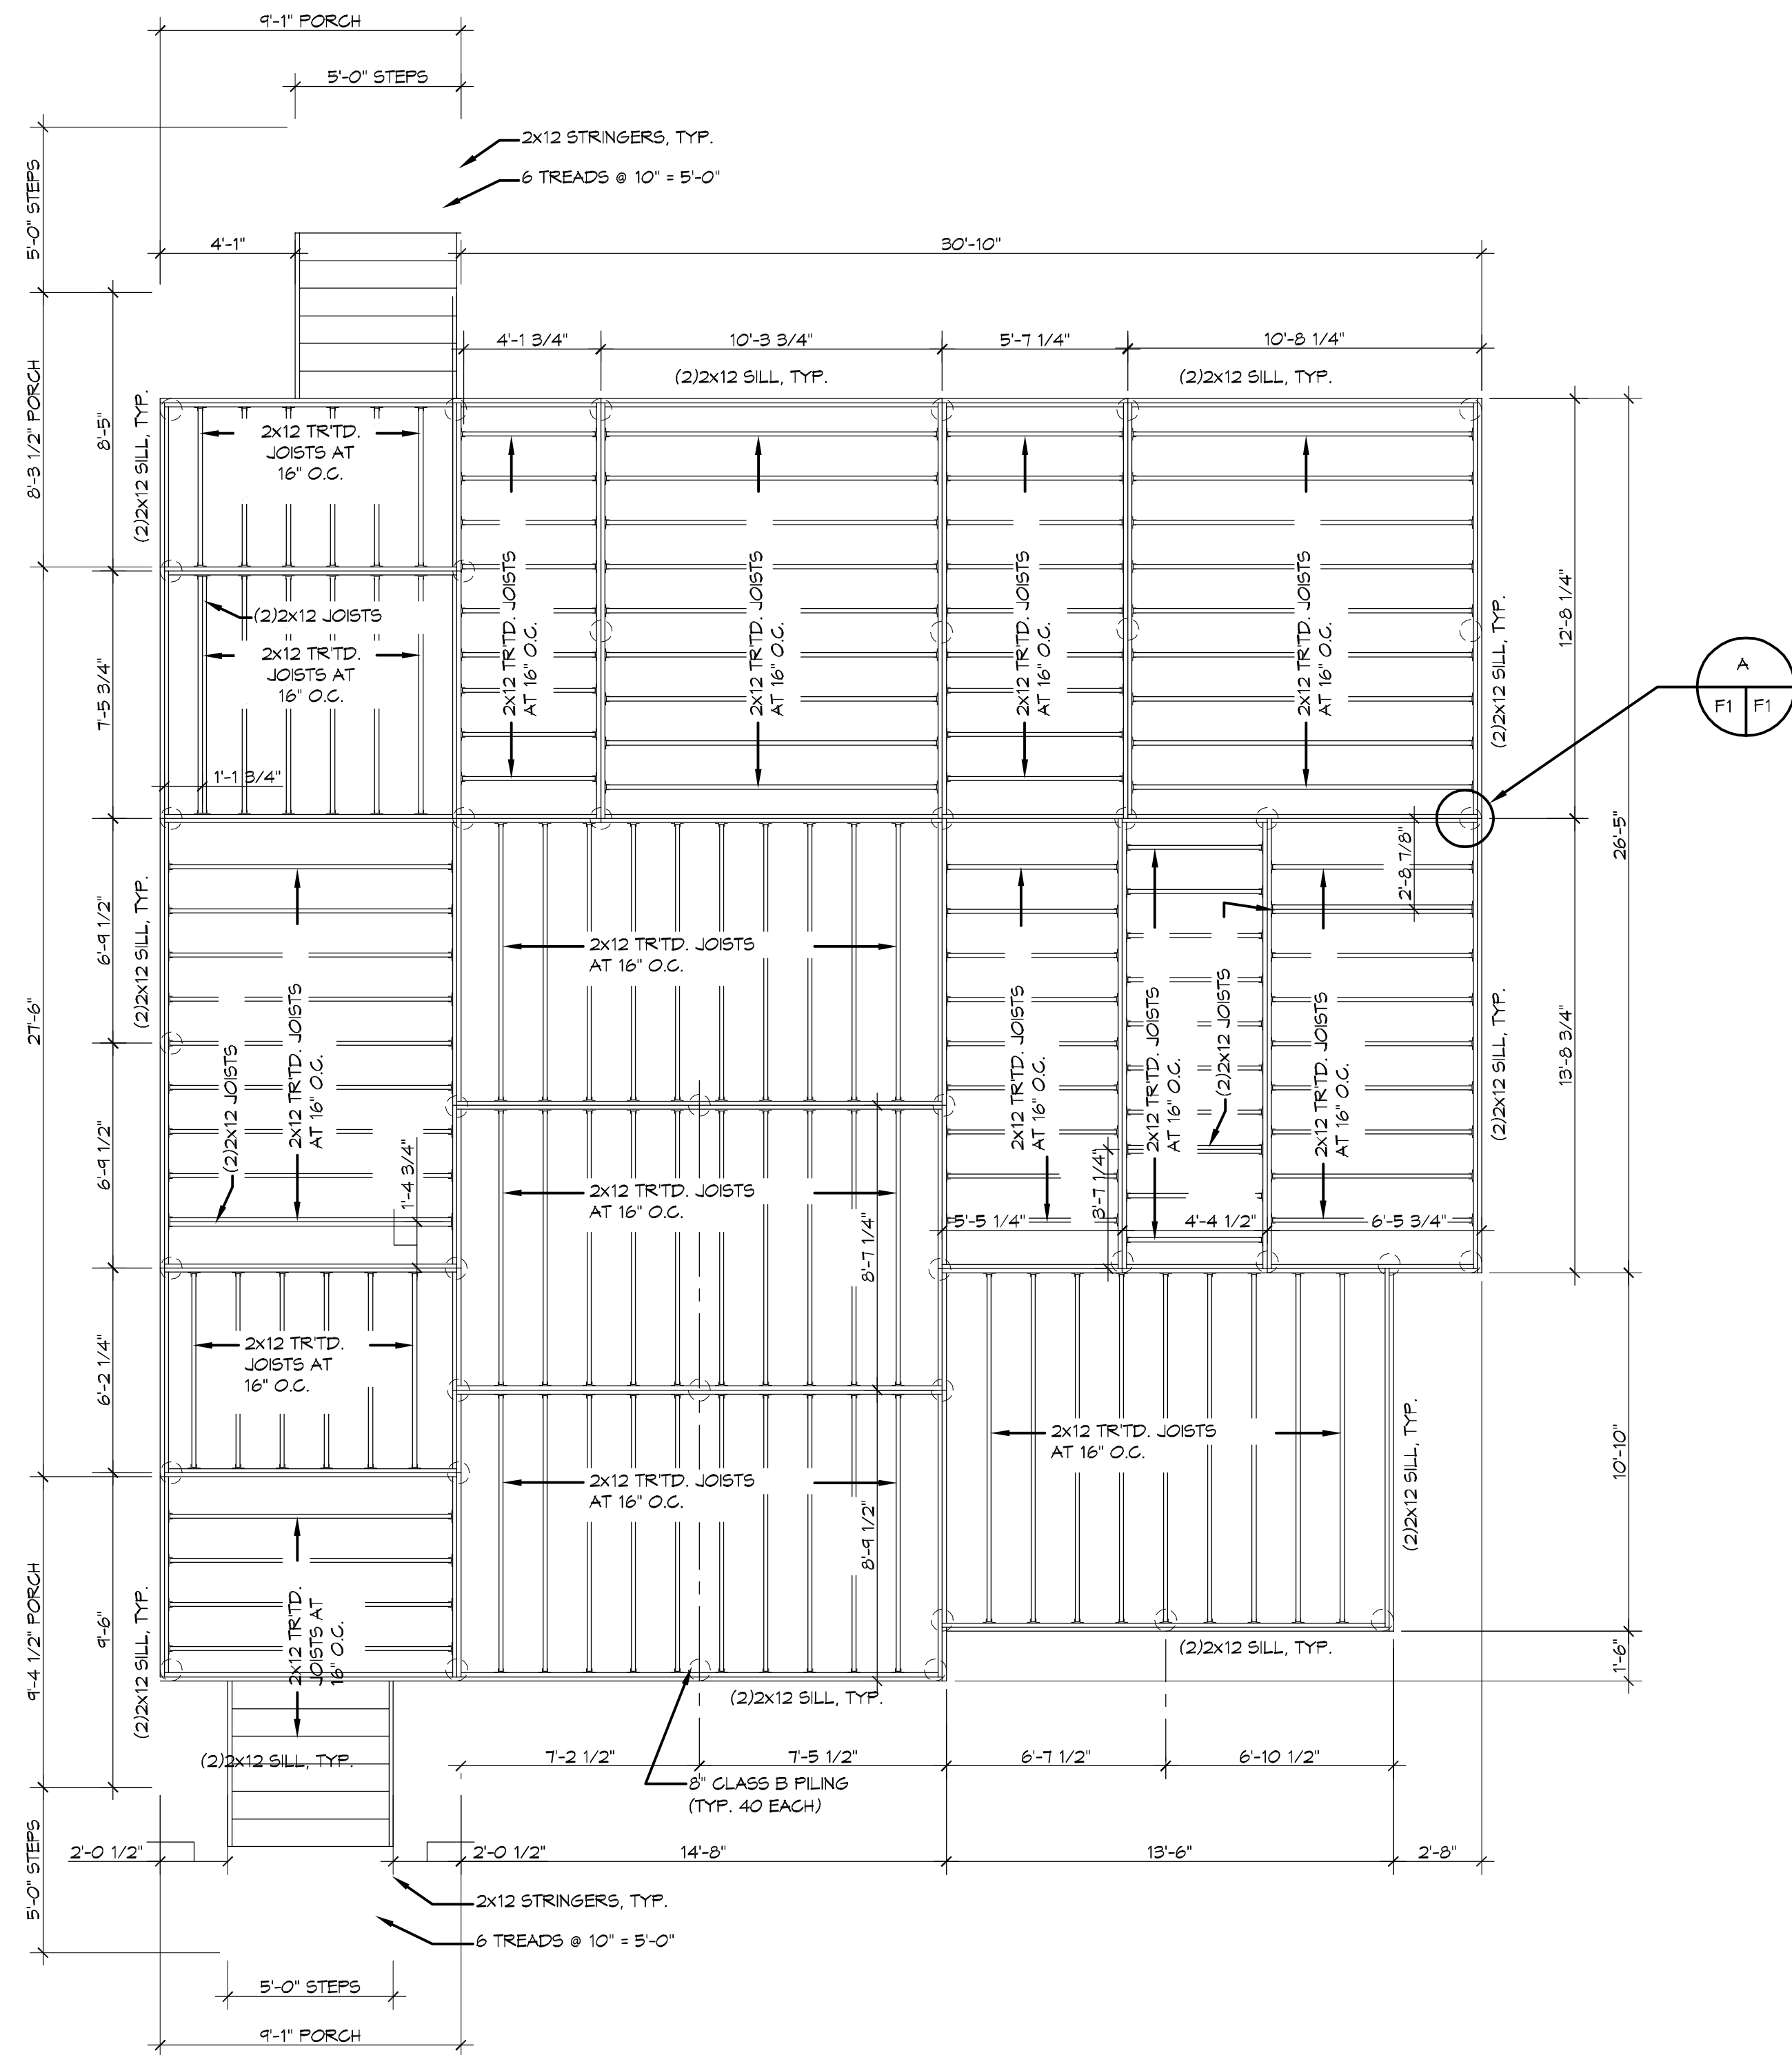

FRAMING NOTES

- DAMMON**
ENGINEERING, INC.

Chief Architect: Kevin J. Kinchen, NCARB
Chief Engineer: Brian Mistich, PE
554 Old Spanish Trail
Stuart, LA 70458

[illegible]

SEAL:

50% SUBMITTAL

**NOT FOR
CONSTRUCTION**

LOUISIANA ARMY NATIONAL GUARD
COMPANIES
NEW COMMANDEER'S POST

The above drawings and specifications, designs and arrangements represented hereby are and shall remain the property of Durham Engineering, and no part thereof shall be copied, reproduced or used in connection with any work or project other than the specific project for which they have been prepared and developed without written consent of Durham Engineering. Visual contact with these drawings or specifications shall constitute conclusive evidence of acceptance of these restrictions.





JOB No:	2210	DATE:	JULY 22, 2014
DRAWN BY:	JTL	CHECKED BY:	CKD

SHEET TITLE:
FRAMING PLAN -
DETAILS AND NOTES

DRAWING NUMBER:

S1

SHEET No: 2 of 10

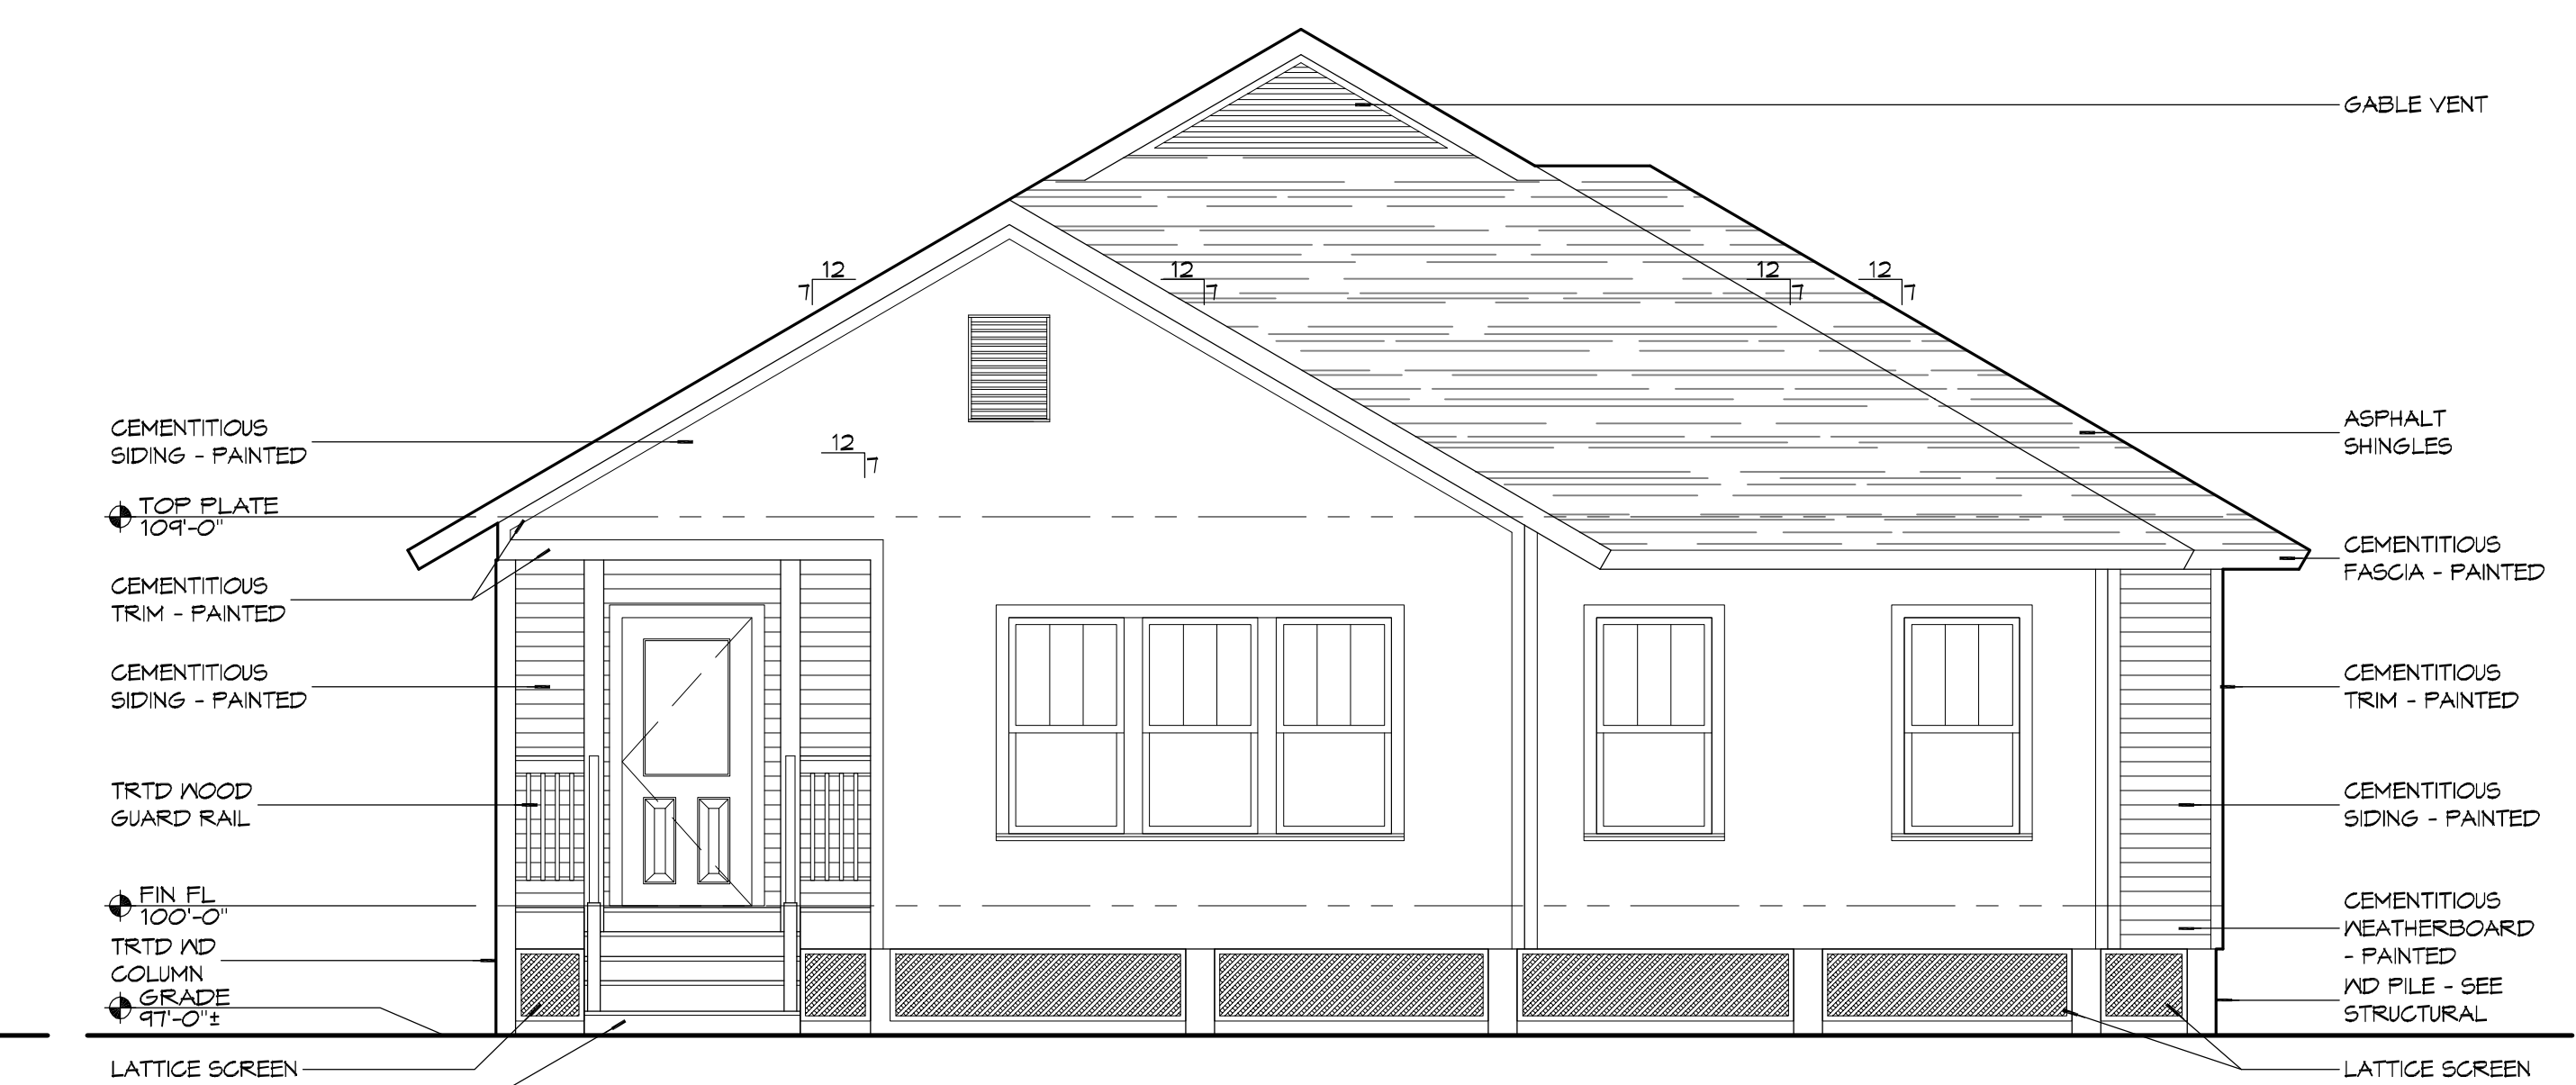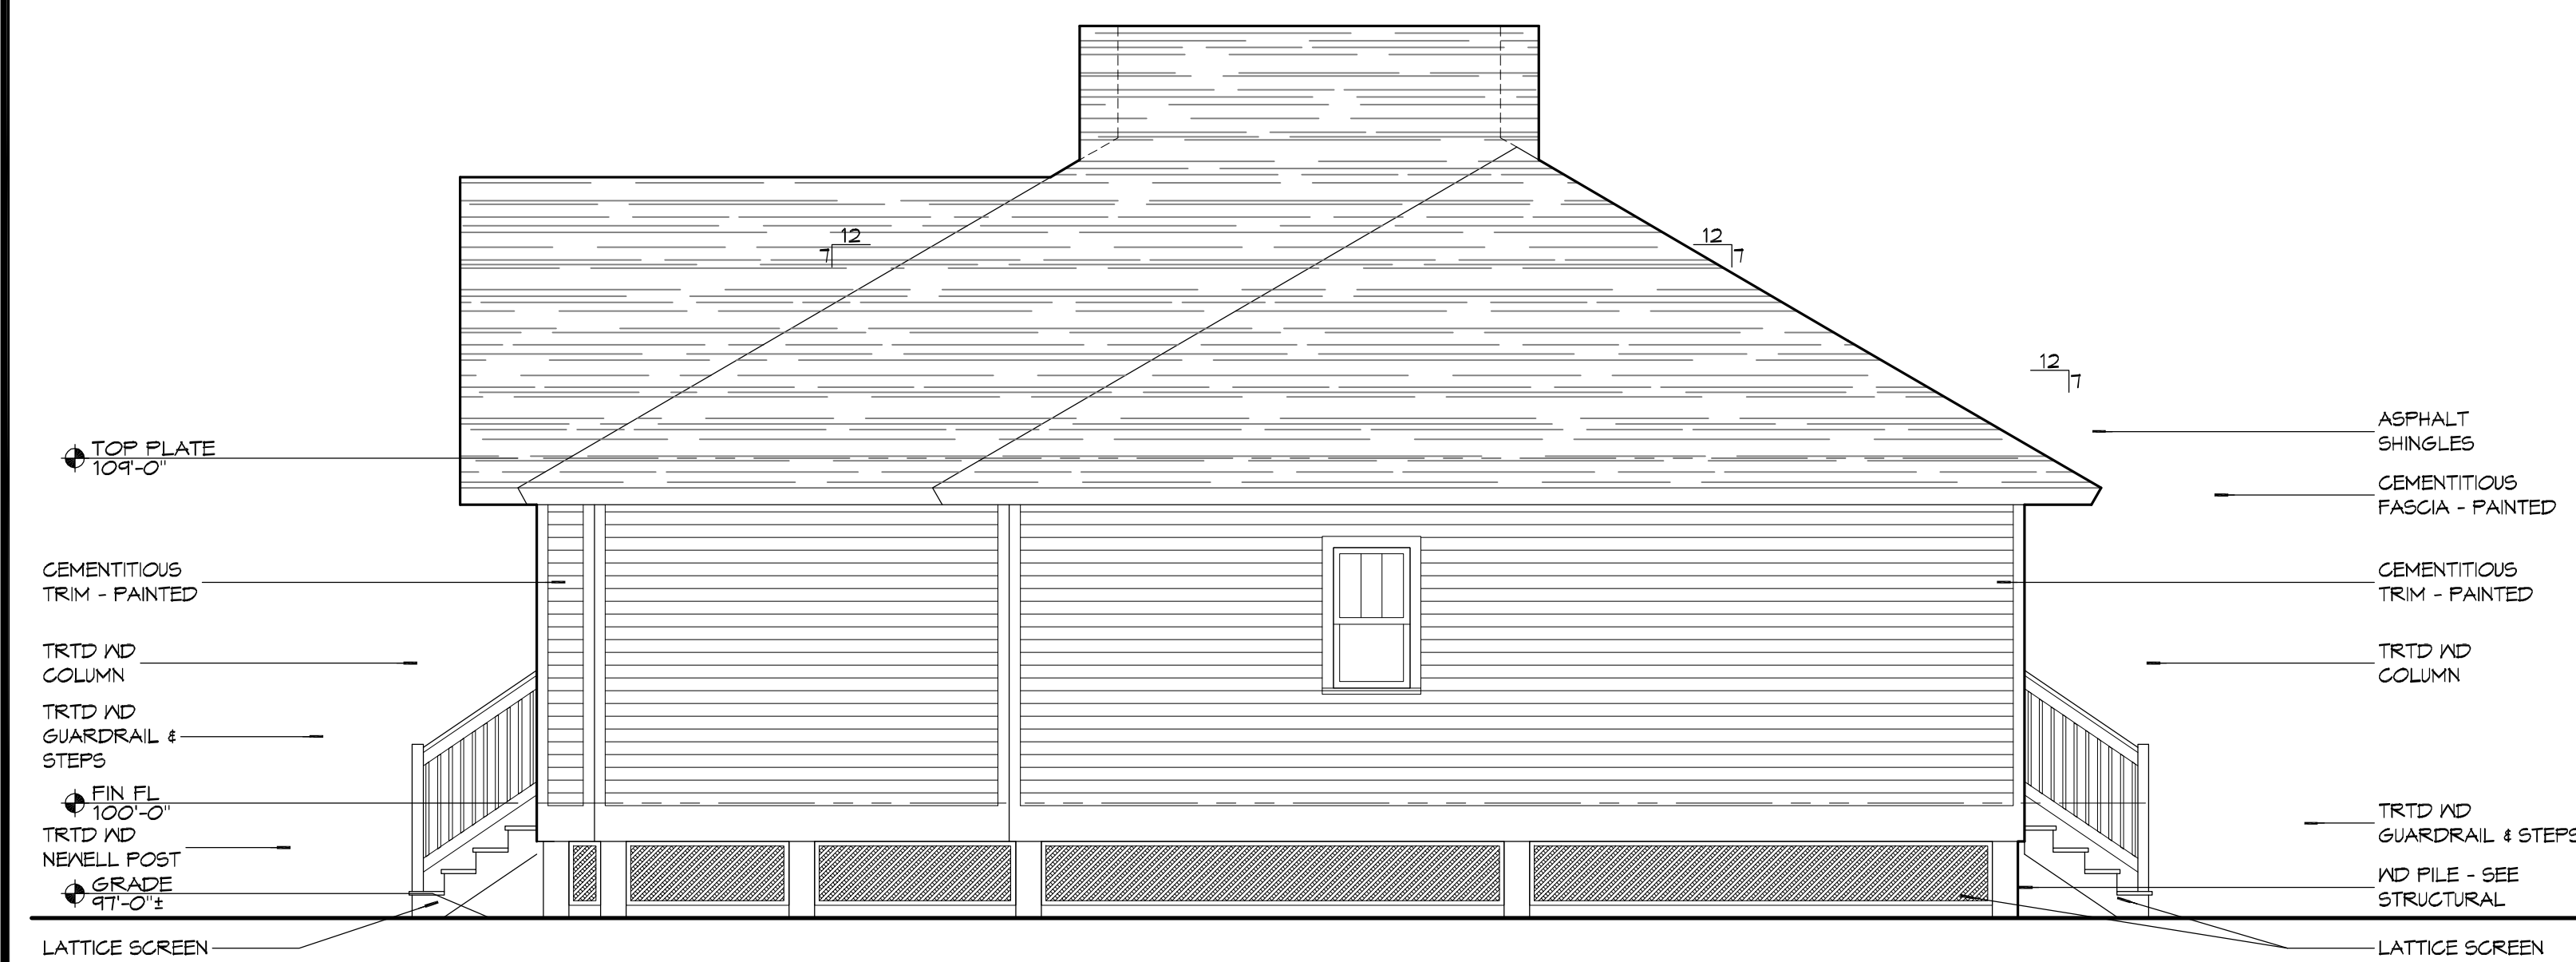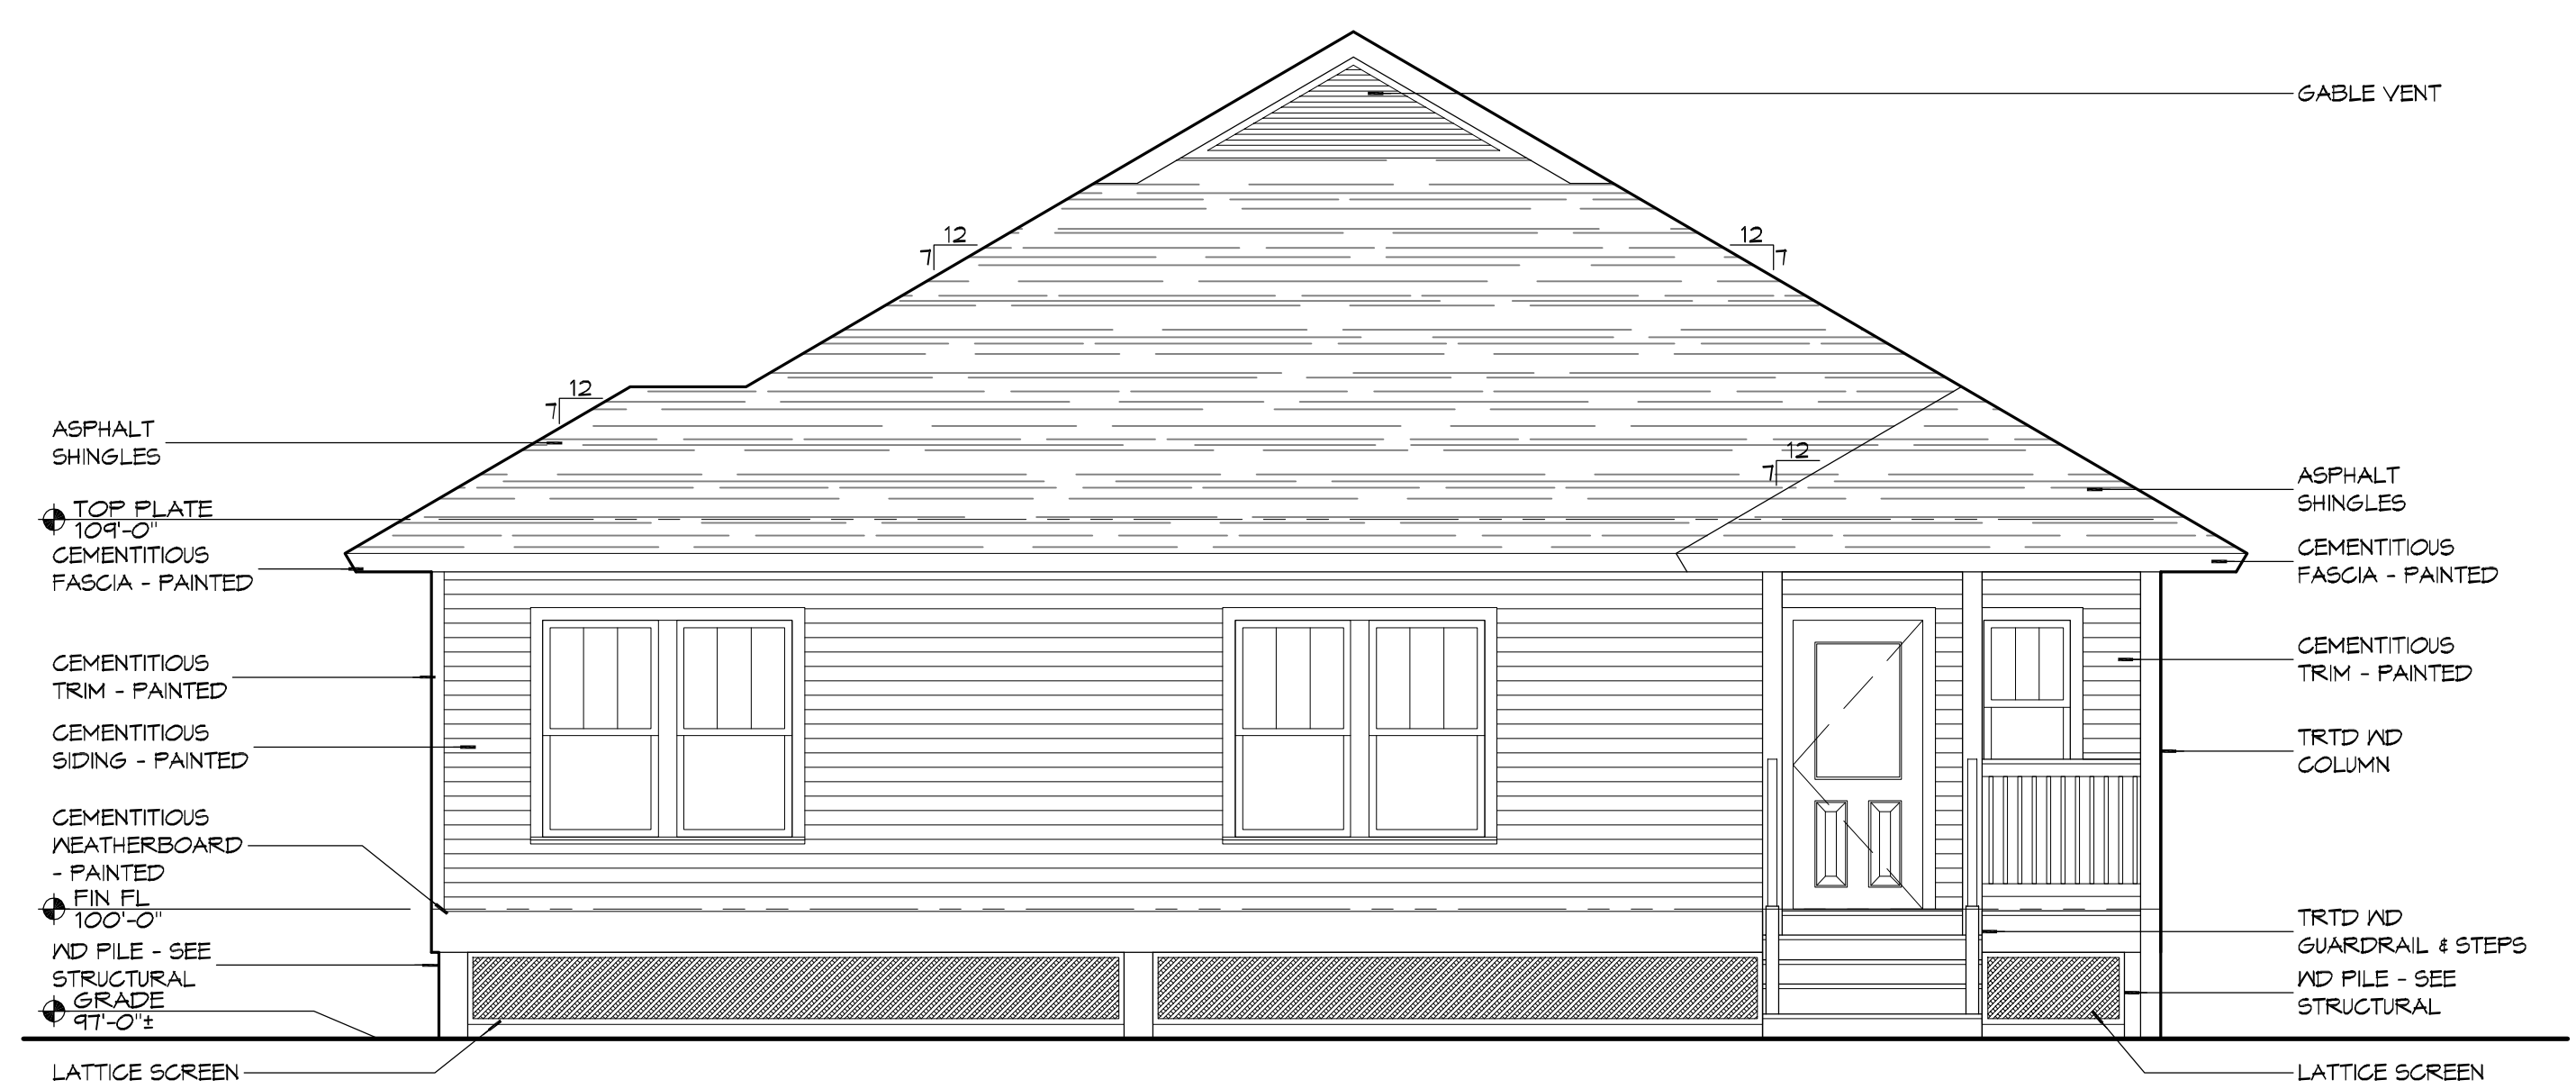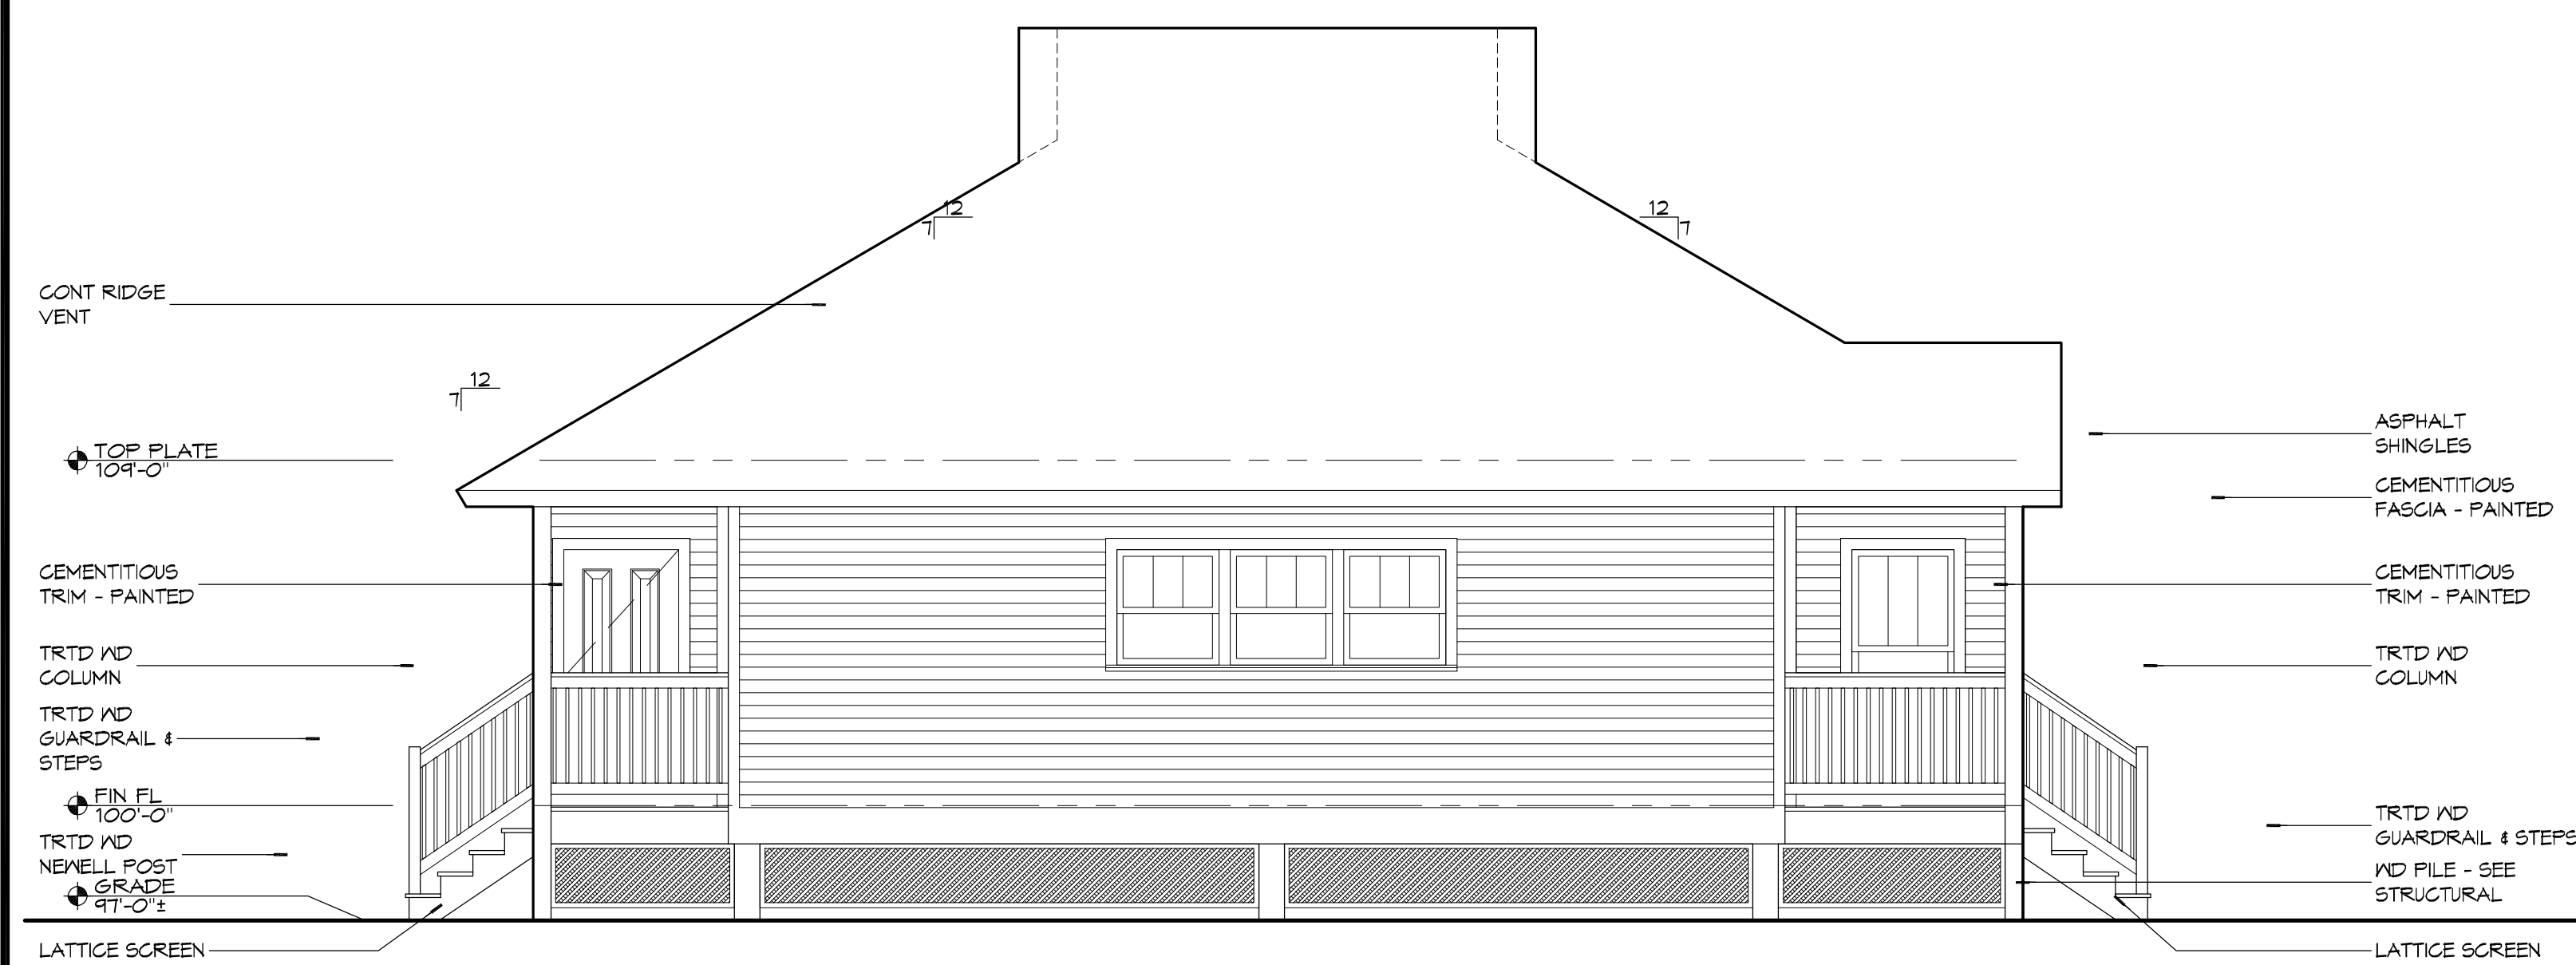[illegible]

SEAL:

50% SUBMITTAL

NOT FOR

 
CONSTRUCTION


[illegible]

SHEET TITLE:
EXTERIOR ELEVATIONS

DRAWING NUMBER:

SHEET No: 00 of 10



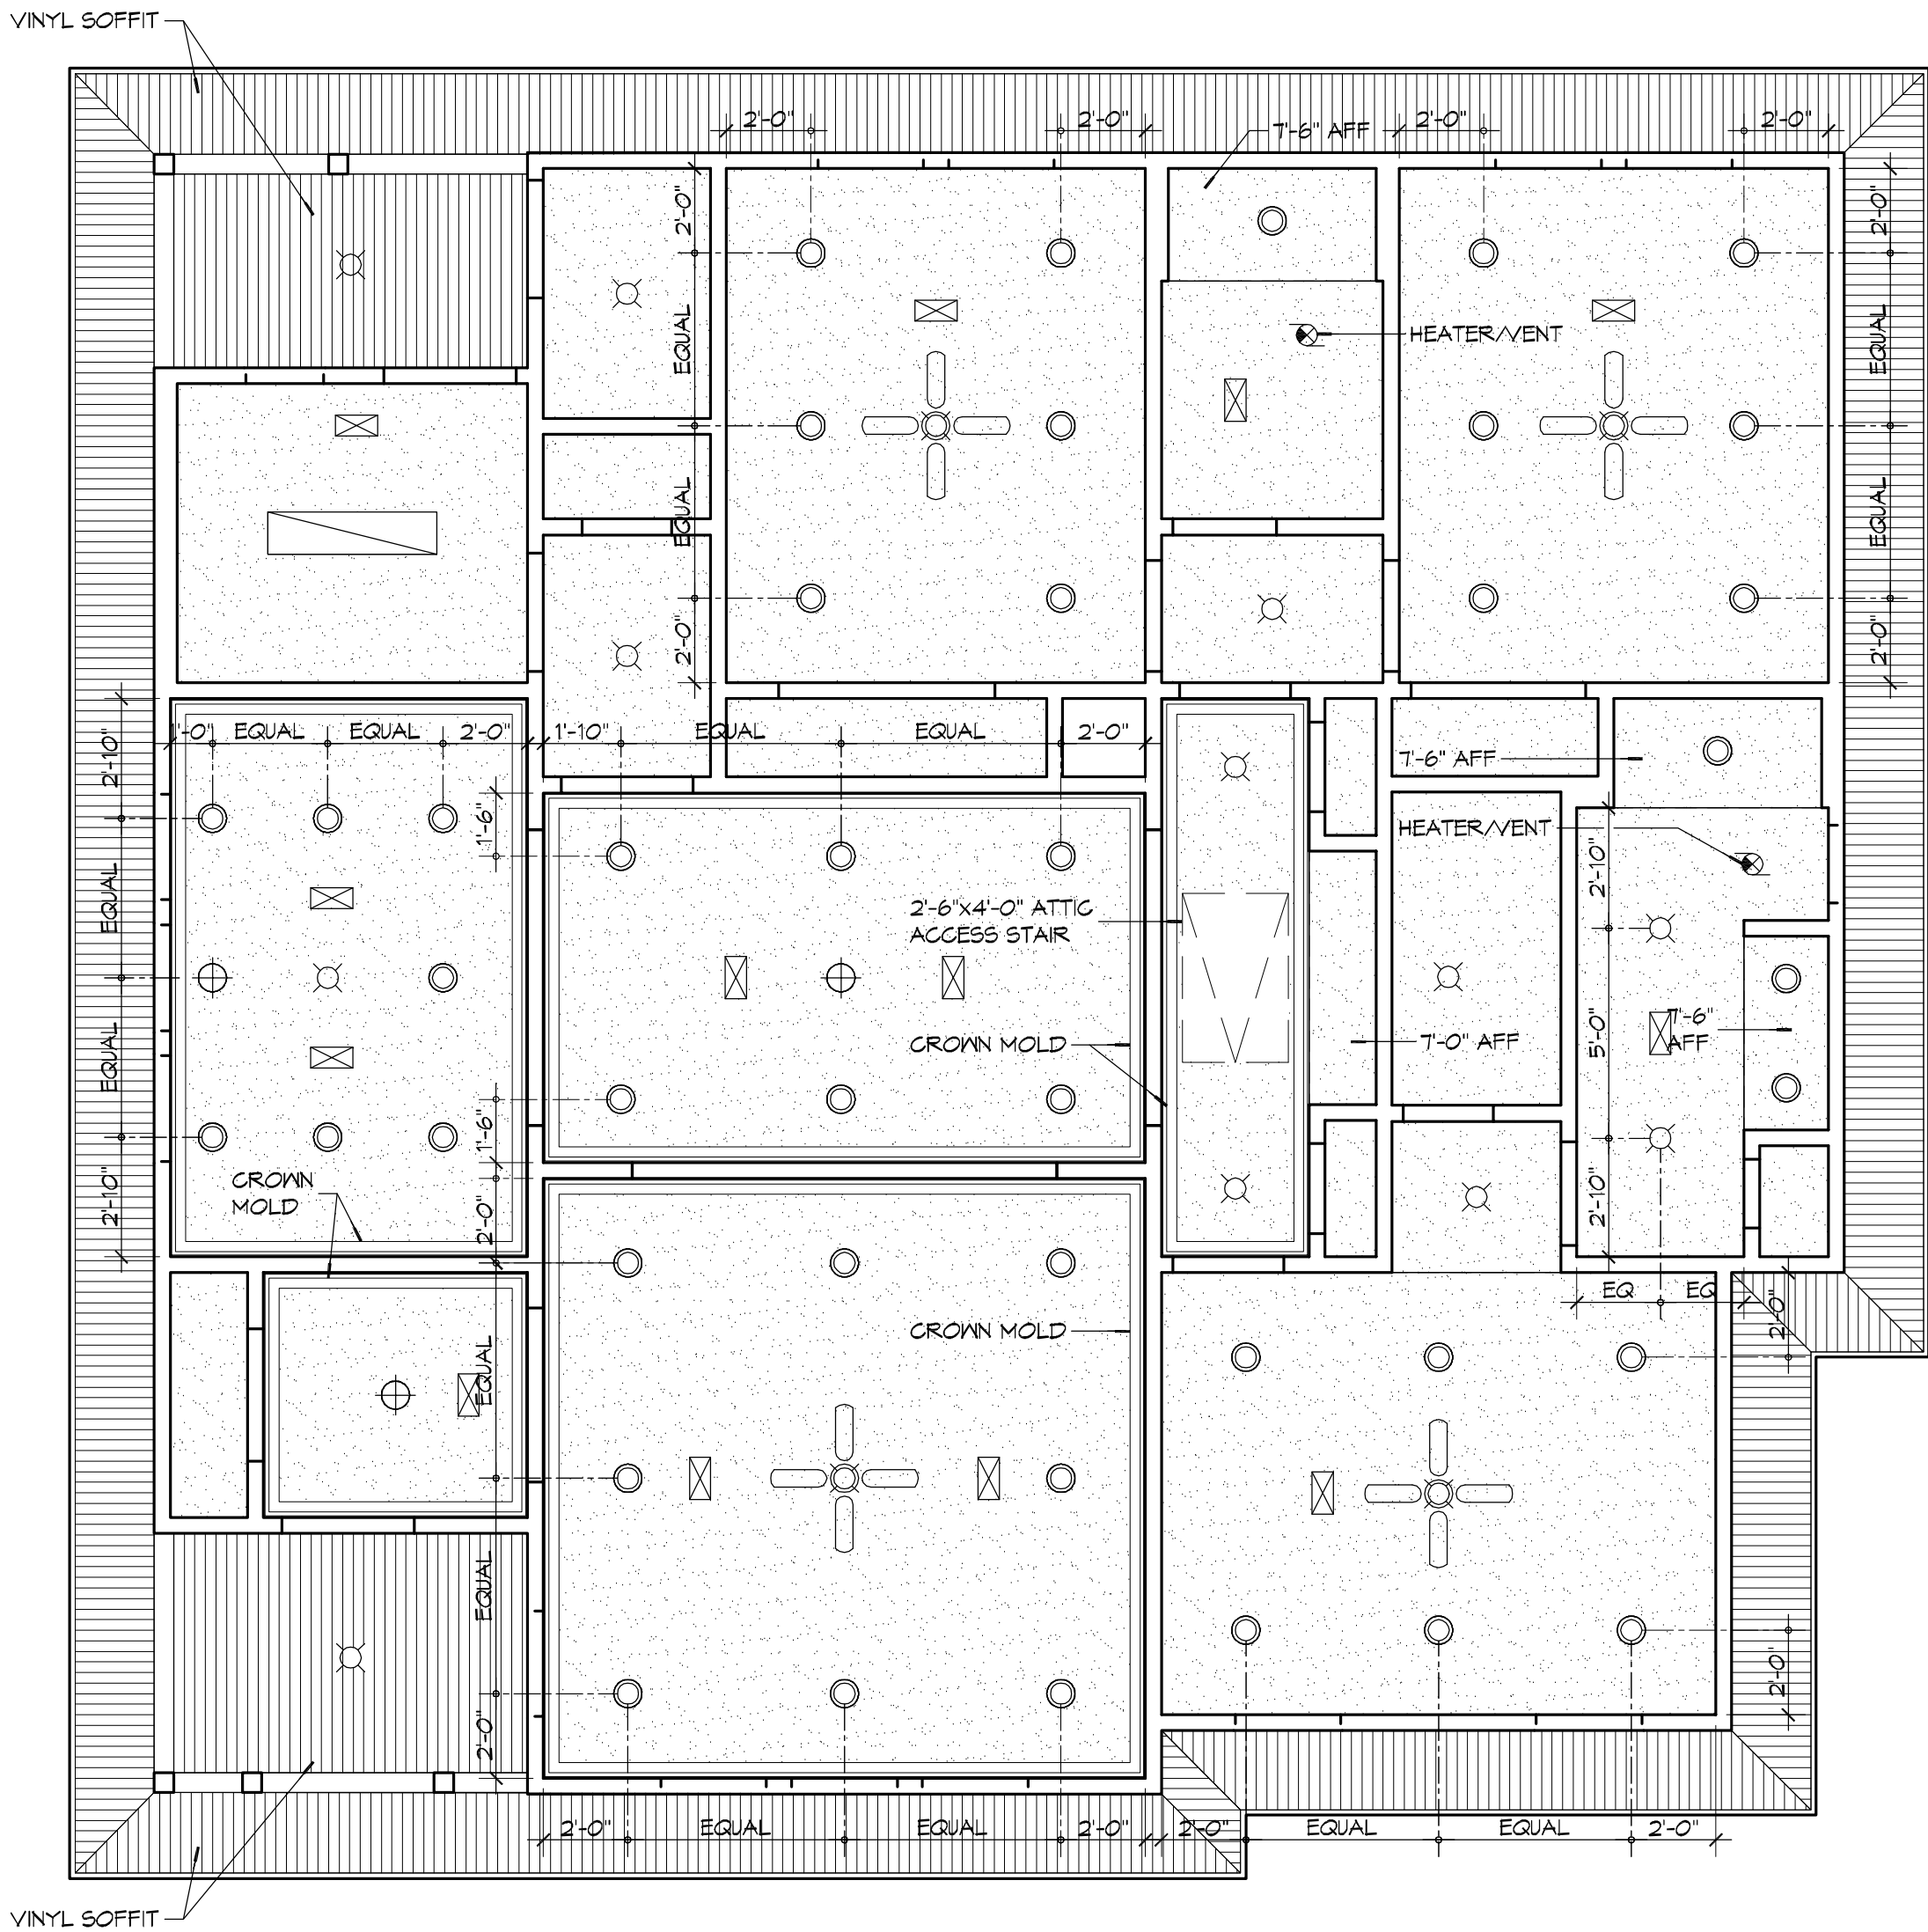

1 REFLECTED CEILING PLAN

SCALE: 1/4" = 1'-0"

GENERAL RCP NOTES

1. CEILING HEIGHT TO BE 9'-0" AFF UNLESS NOTED OTHERWISE.
2. CEILING MATERIAL SHALL BE PAINTED GMB UNLESS NOTED OTHERWISE. REFER TO FINISH SCHEDULE FOR MORE DETAILED INFORMATION RE GMB TYPE.
3. CEILINGS SHALL HAVE COURSE ORANGE PEEL FINISH.
4. REFER TO ELECTRICAL LIGHTING PLAN FOR LIGHT FIXTURE TYPE.

DAMMON
ENGINEERING, INC.

Architects & Engineers
www.dammonengineering.com
info@dammonengineering.com
554 Old Spanish Trail
Slidell, LA 70458
PH: 985.649.5932
F: 985.641.5950

#	DESCRIPTION	REVISIONS	DATE

SEAL:

50% SUBMITTAL


NOT FOR CONSTRUCTION

LOUISIANA ARMY NATIONAL GUARD CAMP VILLERE			
NEW COMMANDER'S POST			
JOB No:	2210	DATE:	JULY 22, 2014
DRAWN BY:	KJK	CHECKED BY:	KJK

SHEET TITLE:
REFLECTED CEILING PLAN

DRAWING NUMBER:

A4

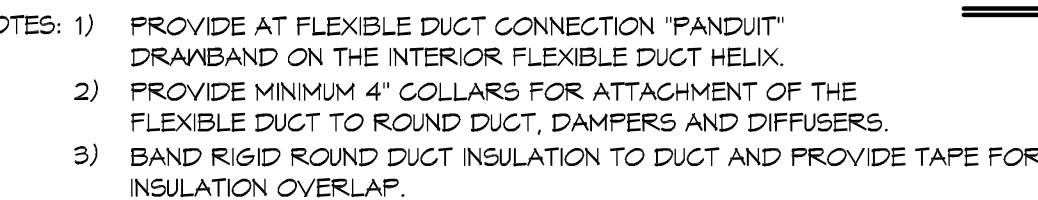



NOTE: ALL AIR HANDLING UNITS TO HAVE A SINGLE-POINT CONNECTION FOR THE BLOWER & HEATING ELEMENT.

SHEET No: 00 of 10

VOLTAGE:120/240V, 1Ø, 4W
ENCLOSURE: SURFACE MOUNTED 200A PANELBOARD, 22K AIC
200A MB, EQUIPMENT GND BAR & BOLT-ON BREAKERS

2 ELECTRICAL PLAN-LIGHTING

ID	DESCRIPTION	MOUNTING	MFR	PART #	FINISH	LAMPS #	LAMP TYPE	WATTAGE	FIXTURE NOTES	INSTALLATION NOTES
L-1	4-LIGHT CHANDELIER	SURFACE	LEBACH	34618	BRUSHED NICKEL	4	HALOGEN G9 PIN BASE	160		HARDWIRED
L-10	SHELDON COLLECTION BATH BAR	WALL	HAMPTON BAY	EN1315BA	BRUSHED NICKEL	4	A19 BULB 1/2" E-26 MEDIUM BASE	240		HARDWIRED
L-11	AIRTIGHT I/C RATED RECESSED HOUSING 1/2" LIGHT TRIM	RECESSED	HALO	356670	WHITE	1	A19 BULB 1/2" E-26 MEDIUM BASE	240	HOUSING: JUNO #9T543 AIRTIGHT I/C RATED	HARDWIRED
L-12	AIRTIGHT I/C RATED RECESSED HOUSING 1/2" SHOWER LIGHT TRIM	RECESSED	JUNO	54698	WHITE	1	A19 BULB 1/2" E-26 MEDIUM BASE	240	HOUSING: JUNO #9T543 AIRTIGHT I/C RATED	HARDWIRED
L-13	AIRTIGHT I/C RATED RECESSED HOUSING 1/2" OPEN LIGHT TRIM	RECESSED	UTILITECH	404540	WHITE	1	A19 BULB 1/2" E-26 MEDIUM BASE	240	HOUSING: JUNO #9T543 AIRTIGHT I/C RATED	HARDWIRED
L-13	180 DEG MOTION-ACTIVATED FLOOD LIGHT 1/2" TIMER	FLUSH	UTILITECH	UT-5412-WH	WHITE	2	PAR38 1/2" MEDIUM BASE (E-26)	240	PROVIDE COMPATIBLE LED LAMP	HARDWIRED, MOUNT IN SOFFIT
L-14	OUTDOOR WALL-MOUNT LIGHT	WALL	PROGRESS LIGHTING	565440	BRUSHED NICKEL	1	A19 BULB 1/2" E-26 MEDIUM BASE	75	PROVIDE COMPATIBLE LED LAMP	HARDWIRED
L-2	15 IN CEILING MOUNT FIXTURE	SURFACE	BELL AIR LIGHTING	13882EN	BRUSHED NICKEL	3	A19 BULB 1/2" E-26 MEDIUM BASE	180		HARDWIRED
L-3	WISTEN 3 7/8" MINI PENDANT	PENDANT	PROGRESS LIGHTING	P516T-09	BRUSHED NICKEL	1	A19 BULB 1/2" E-26 MEDIUM BASE	100		HARDWIRED
L-4	SEMI-FLUSH MOUNT LIGHT	SEMI-FLUSH	DVI	DVP9112EN	BRUSHED NICKEL	2	A19 BULB 1/2" E-26 MEDIUM BASE	200		HARDWIRED
L-5	ALBION SERIES 6" SEMI-FLUSH MOUNT LIGHT	SEMI-FLUSH	Z-LITE	171-6W-SF	BRUSHED NICKEL	2	A19 BULB 1/2" E-26 MEDIUM BASE	60		HARDWIRED
L-6	CEILING MOUNTED FIXTURE	FLUSH	PROGRESS LIGHTING	P3410-09	BRUSHED NICKEL	2	A19 BULB 1/2" E-26 MEDIUM BASE	60		HARDWIRED
L-8	WINDMERE SERIES CEILING FAN 1/2" LIGHT KIT	DOWNROD	HUNTER	54039	BRUSHED NICKEL	2	B10 BULB 1/2" E-12 CANDELABRA BASE	40	PROVIDE COMPATIBLE LED LAMP	HARDWIRED
L-9	OUTDOOR FLUSH-MOUNT LIGHT	FLUSH	VOLUME INTERNATIONAL	V8790-6	WHITE	1	A19 BULB 1/2" E-26 MEDIUM BASE	100	PROVIDE COMPATIBLE LED LAMP	HARDWIRED

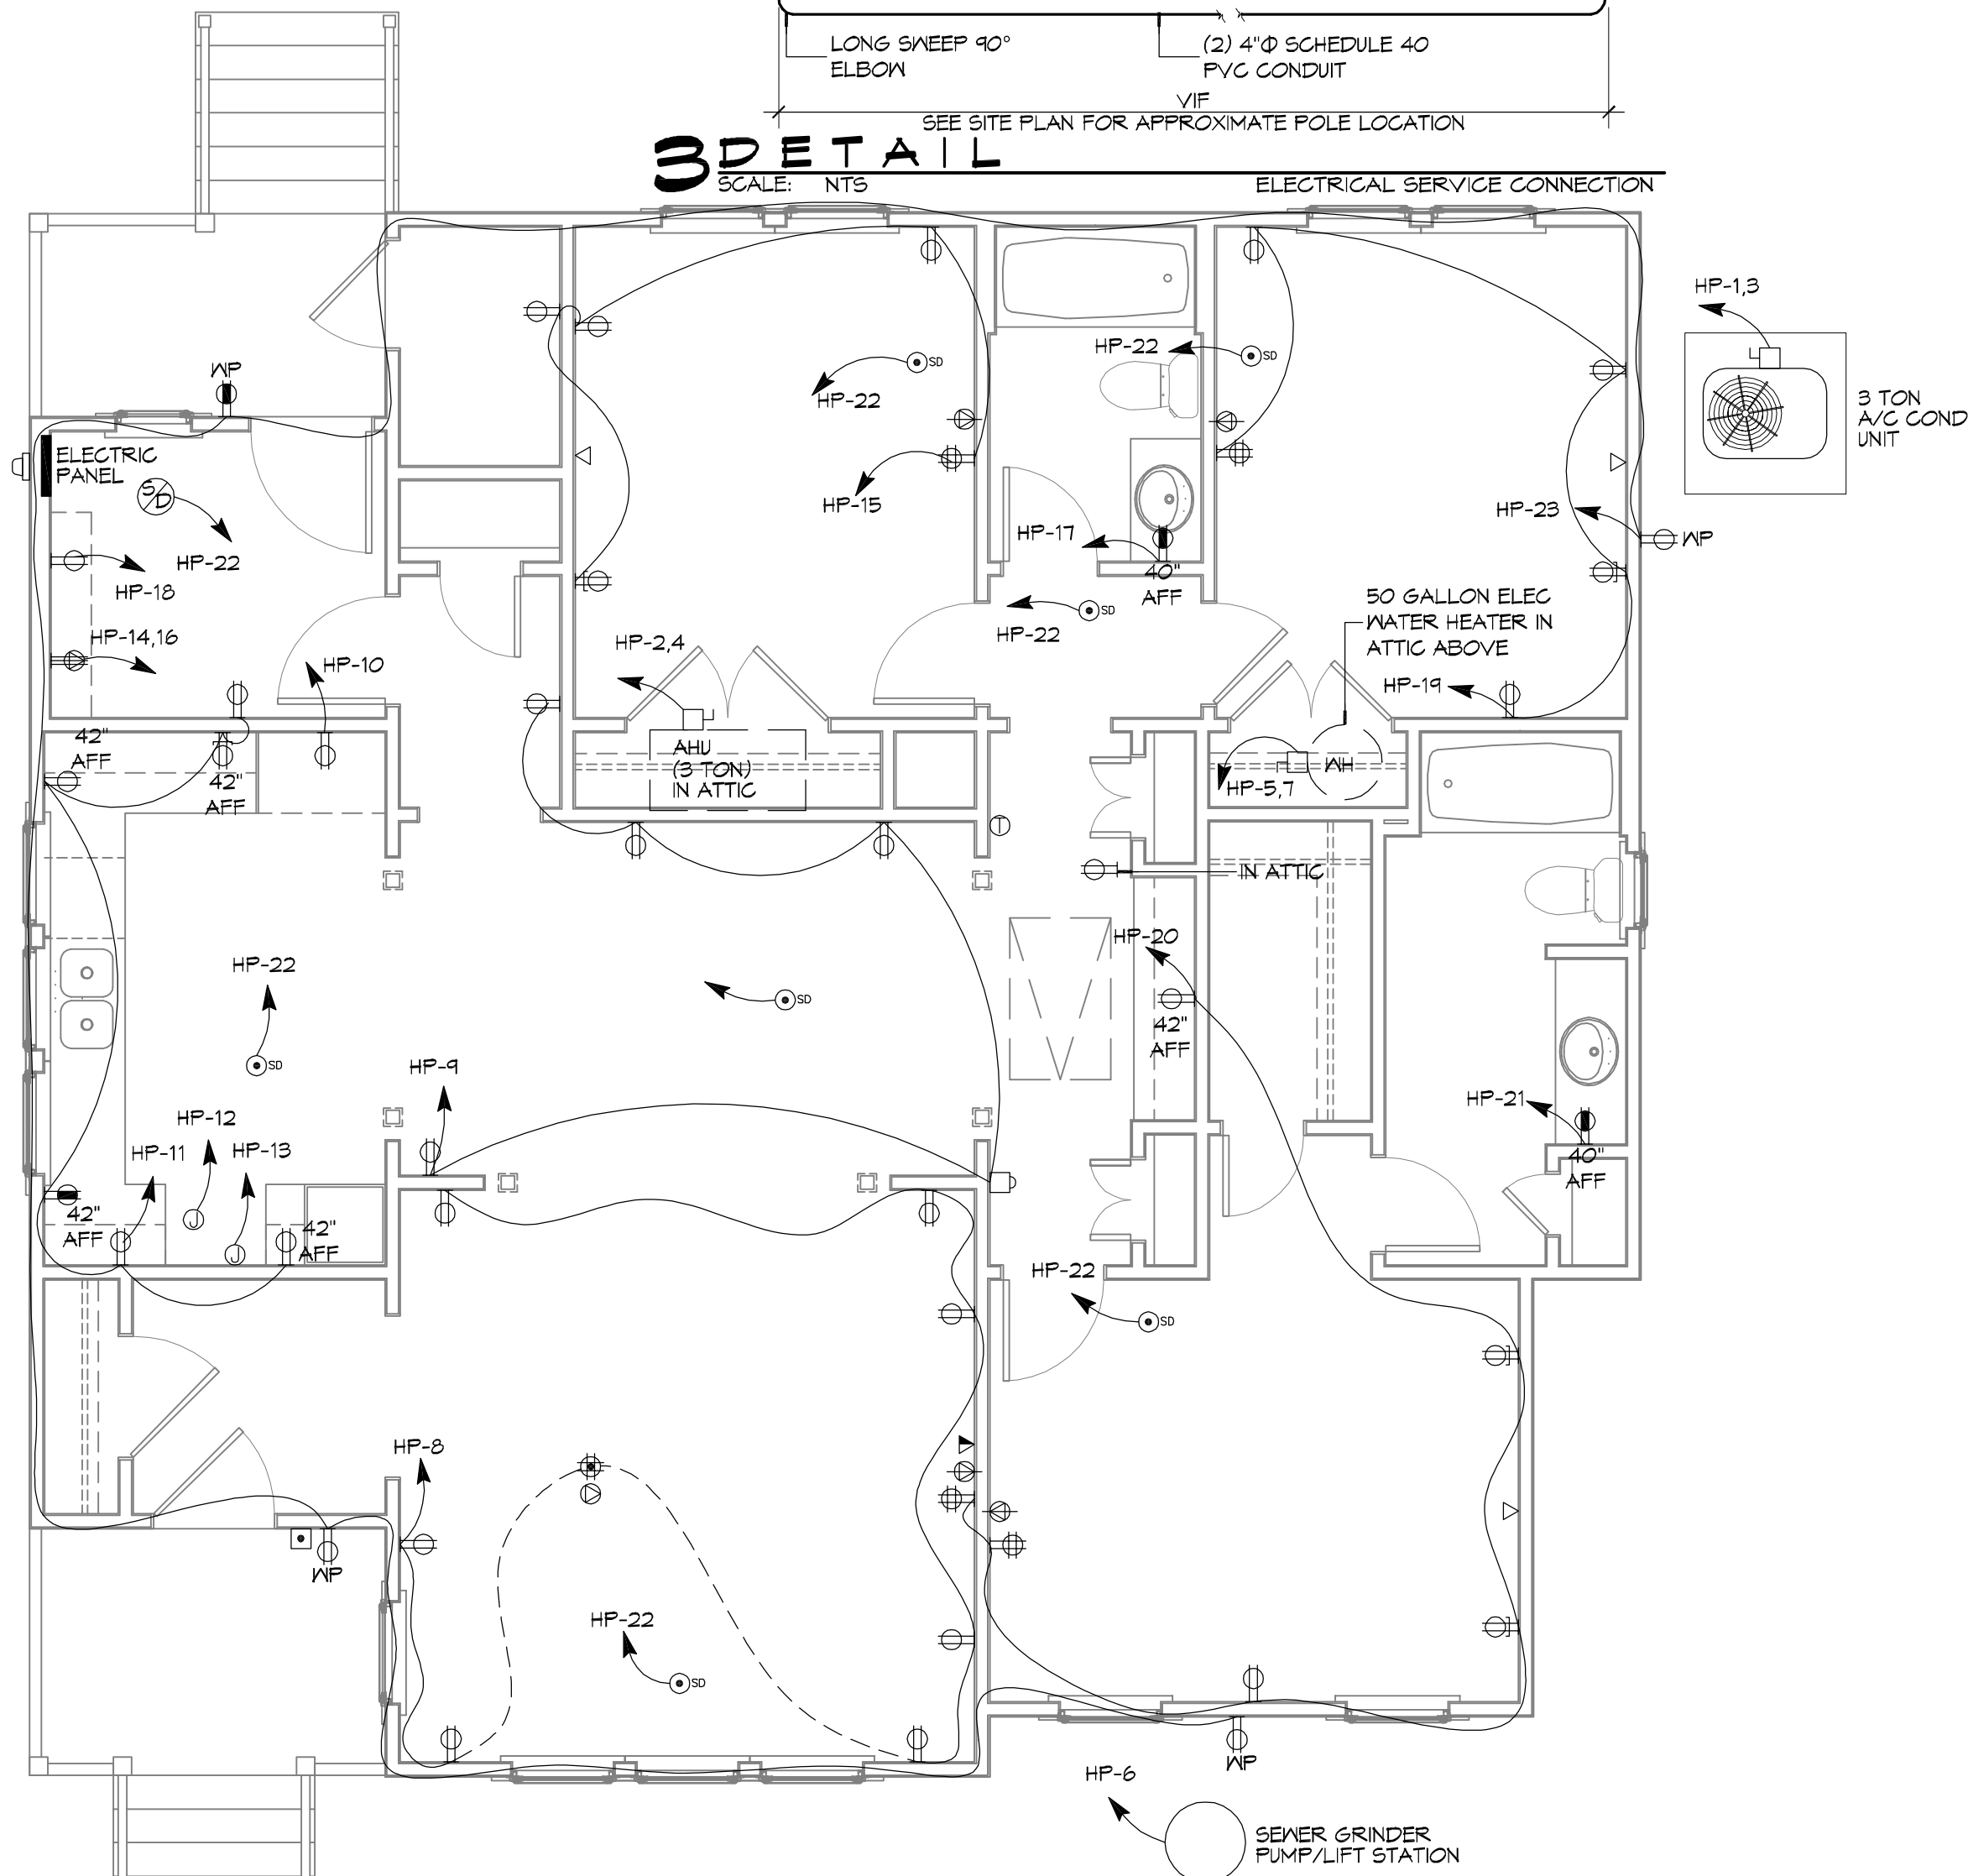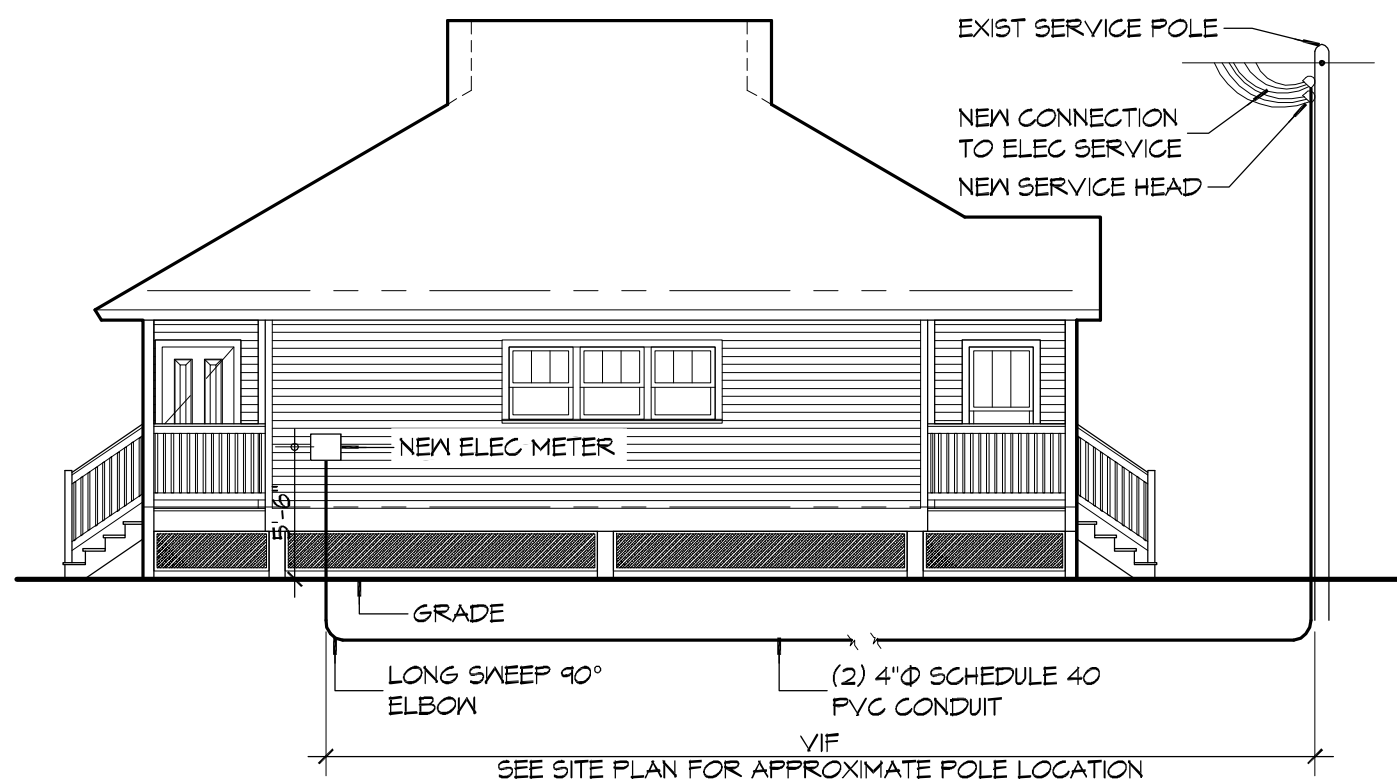

1 ELECTRICAL PLAN - POWER

1. DRAWINGS ARE DIAGNOSTIC ONLY. FURNISH ALL CONDUIT, WIRING, PANELS, BREAKERS, DISCONNECTS, ACCESSORIES, ETC. FOR COMPLETE INSTALLATION RATHER OR NOT EVERY ITEM IS SHOWN OR SPECIFIED.
2. THESE DRAWINGS ARE INTENDED AS GENERAL GUIDELINES FOR PURPOSES OF ESTABLISHING CERTAIN MIN. CRITERIA, AND DO NOT NECESSARILY REPRESENT THE FINAL LAYOUT, ARRANGEMENT, SIZE, BRAND NAME, CAPACITY OR OTHER CHARACTERISTICS OF THE ENGINEERED SYSTEM. SYSTEM SHALL BE DESIGNED IN ACCORDANCE WITH ALL APPLICABLE CODES, STANDARDS AND REQUIREMENTS OF LOCAL UTILITY OFFICIALS.
3. INSTALL GFCI OUTLETS AS REQUIRED BY APPLICABLE CODES.
4. INSTALL HARDWIRED SMOKE DETECTORS WITH BATTERY BACKUP AS REQUIRED. INTER-CONNECT DETECTORS SO THAT ALL WILL SOUND SHOULD ONE DETECTOR ACTIVATE.
5. SOME EQUIPMENT SHOWN ON OTHER PLANS MAY REQUIRE ELECTRICAL SERVICE, SUCH AS WATER HEATER, CONDENSING UNITS, AIR-HANDLING UNITS, CONDENSATE PUMPS, ETC.. ELECTRICAL CONTRACTOR SHALL INCLUDE ELECTRICAL SERVICE TO ALL SUCH EQUIPMENT. COORDINATE WITH OTHER TRADES CONCERNING CONCERNING ITEMS REQUIRING ELECTRICAL SERVICE. PROVIDE ONE DUPLEX OUTLET AND LIGHT IF UNIT IS IN NONLIT AREA FOR EVERY CONDENSING UNIT AND EVERY AIR-HANDLING UNIT AS REQUIRED BY APPLICABLE CODES. OUTLETS SHALL BE WEATHERPROOF GFCI IF UNIT IS EXPOSED TO WEATHER.
6. OBTAIN NAME PLATE AND RATING OF ALL EQUIPMENT BEFORE ROUGHING IN AND PROVIDE WIRING OF PROPER SIZE, VOLTAGE, AND AMPCACITY. PROVIDE FUSED OR NON-FUSED DISCONNECT SWITCH AS REQUIRED.
7. PROVIDE PANEL BOARDS OF PROPER VOLTAGE AND AMPCACITY FOR ALL ELECTRICAL CIRCUITS.
8. VERIFY SERVICE REQUIREMENTS WITH LOCAL POWER COMPANY INCLUDING TRANSFORMER LOCATIONS AND TYPES, DISCONNECTS AT EXTERIOR OF BLDG., VOLTS AND AMPACITIES AND OTHER DETAILS OF ELECTRICAL CONSTRUCTION. SIZE ALL FEEDERS ACCORDING TO NEC REQUIREMENTS.
9. RUN ALL CABLE CONCEALED IN WALLS, CEILINGS OR FLOORS UNLESS NOTED OTHERWISE.
10. SUPPORT ALL FIXTURES AND OTHER ITEMS RIGIDLY FROM STRUCTURE.
11. INSULATE AND SEAL SOLIDLY BEHIND RECEPTACLES IN EXTERIOR WALLS.
12. ALL SWITCHES AND OUTLETS ON FIRST FLOOR TO BE 1'-0" ABOVE BASE FLOOD ELEVATION.
13. INSTALL GROUND FAULT RECEPTACLES AT RECEPTACLE LOCATIONS WITHIN 5' OF SINKS OR LAVATORIES, AND AT EXTERIOR LOCATIONS. EXTERIOR RECEPTACLES SHALL ALSO BE WEATHERPROOF.
14. WHERE MORE THAN ONE SWITCH OCCURS IN THE SAME LOCATION, THEY SHALL BE INSTALLED IN A GANG TYPE BOX UNDER ONE COVER PLATE.
15. ALL OUTLETS SHALL BE INSTALLED 18" AFF UNLESS NOTED OTHERWISE. SEE ELECTRICAL POWER PLAN FOR INDICATED MOUNTING HEIGHT.
16. REFER TO REFLECTED CEILING PLAN FOR RECESSED LIGHT FIXTURE LOCATIONS.

	DUPLEX OUTLET		220 VOLT DRYER OUTLET
42" AFF	COUNTER-HT DUPLEX OUTLET		120V SMOKE DETECTOR
	QUAD OUTLET		W/ 9VDC BATTERY BACKUP
	DUPLEX OUTLET W/ USB CHARGER		COAXIAL OUTLET
	FLOOR QUAD OUTLET		THERMOSTAT
	FLOOR TELEPHONE BOX		DISCONNECT DOOR BELL
	DATA OUTLET (WALL)		JUNCTION BOX
	TELEPHONE OUTLET (WALL)		DOOR BELL JUNCTION BOX
	GROUND FAULT INTERRUPTER (GFI)		DOOR BELL
WP	OUTLET W/ WEATHER PROOF COVER		WIRING CONCEALED IN CEILING OR WALL
	METER		WIRING CONCEALED IN FLOOR
			EXPOSED WIRING
			HOME RUN TO PANEL BOARD

	FAN/LIGHT COMBINATION		WALL MOUNTED LIGHT FIXTURE
	RECESSED LIGHT FIXTURE (6"Ø)		WALL SWITCH - SINGLE POLE
	SURFACE MOUNTED LIGHT FIXTURE		WALL SWITCH - THREE-WAY
	PENDANT LIGHT FIXTURE		WALL SWITCH - DIMMER
	EXHAUST FAN		MOTION ACTIVATED FLOOD LIGHT
	EXHAUST FAN/HEATER		MOTION SENSOR W/ PHOTOCELL

[illegible]

SEAL:

50% SUBMITTAL

NOT FOR

CONSTRUCTION

LOUISIANA ARMY NATIONAL GUARD CAMP VILLERE		NEW COMMANDER'S POST	
JOB NO:	2210	DATE:	JULY 22, 2014
DRAWN BY:	JTL	CHECKED BY:	CKD

The above drawings are for information. Changes and/or supplements to previous drawings are not to be made without the approval of the Engineer. The Engineer is not responsible for the accuracy of the information furnished by the customer. The Engineer is not responsible for the accuracy of the information furnished by the customer. The Engineer is not responsible for the accuracy of the information furnished by the customer.

SHEET TITLE:
ELECTRICAL PLANS -
POWER, LIGHTING,
AND PANEL DIAGRAM

DRAWING NUMBER:

E1

SHEET No: 9 of 10



DAMMON ENGINEERING, INC.

Architects & Engineers
www.dammonengineering.com
Info@dammonengineering.com
PH: 985.649.5832
F: 985.641.5950

Chief Architect: Kevin J. Kinchen, NCARB
Chief Engineer: Brian Misch, PE
554 Old Spanish Trail
Stirrell, LA 70458

[illegible]

SEAL:

50% SUBMITTAL

**NOT FOR
CONSTRUCTION**

D
 4
 4
 3
 9
 1
 4
 Z
 0
 1
 4
 Z
 7
 Σ
 4
 4
 4
 Z
 4
 5
 0
 1

THE
S
O
O
S
-
W
W
D
Z
A
Σ
Σ
O
O
Σ
Σ
Σ
Σ

5123111A

ING No.:

INR No.	DATE.
3310	

MY 27 2014	
------------	--

714

FOR NO:	2210	DATE:	MY 27 2014
---------	------	-------	------------

The above drawings and specifications, designs and arrangements represented thereby are and shall

SHEET TITLE:
PLUMBING PLANS,
RISER DIAGRAMS AND
NOTES

DRAWING NUMBER:

P1

SHEET No:

00 of #